


# CLR PROJECT #01-22-ST-99

## 13TH STREET


### LITTLE ROCK, ARKANSAS

**W. 13TH STREET (FAIR PARK BLVD. TO S. FILLMORE ST.)**

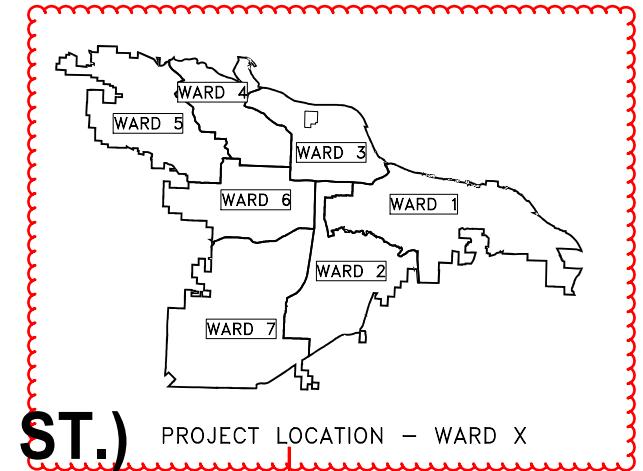

Need updated Ward boundaries.

SHEET NO.	TITLE
C-01	TITLE SHEET
C-02	LEGEND, NOTES, AND QUANTITIES
C-03	TYPICAL SECTIONS 1
C-04	PLAN AND PROFILE 13TH STREET SHEET 1
C-05	PLAN AND PROFILE 13TH STREET SHEET 2

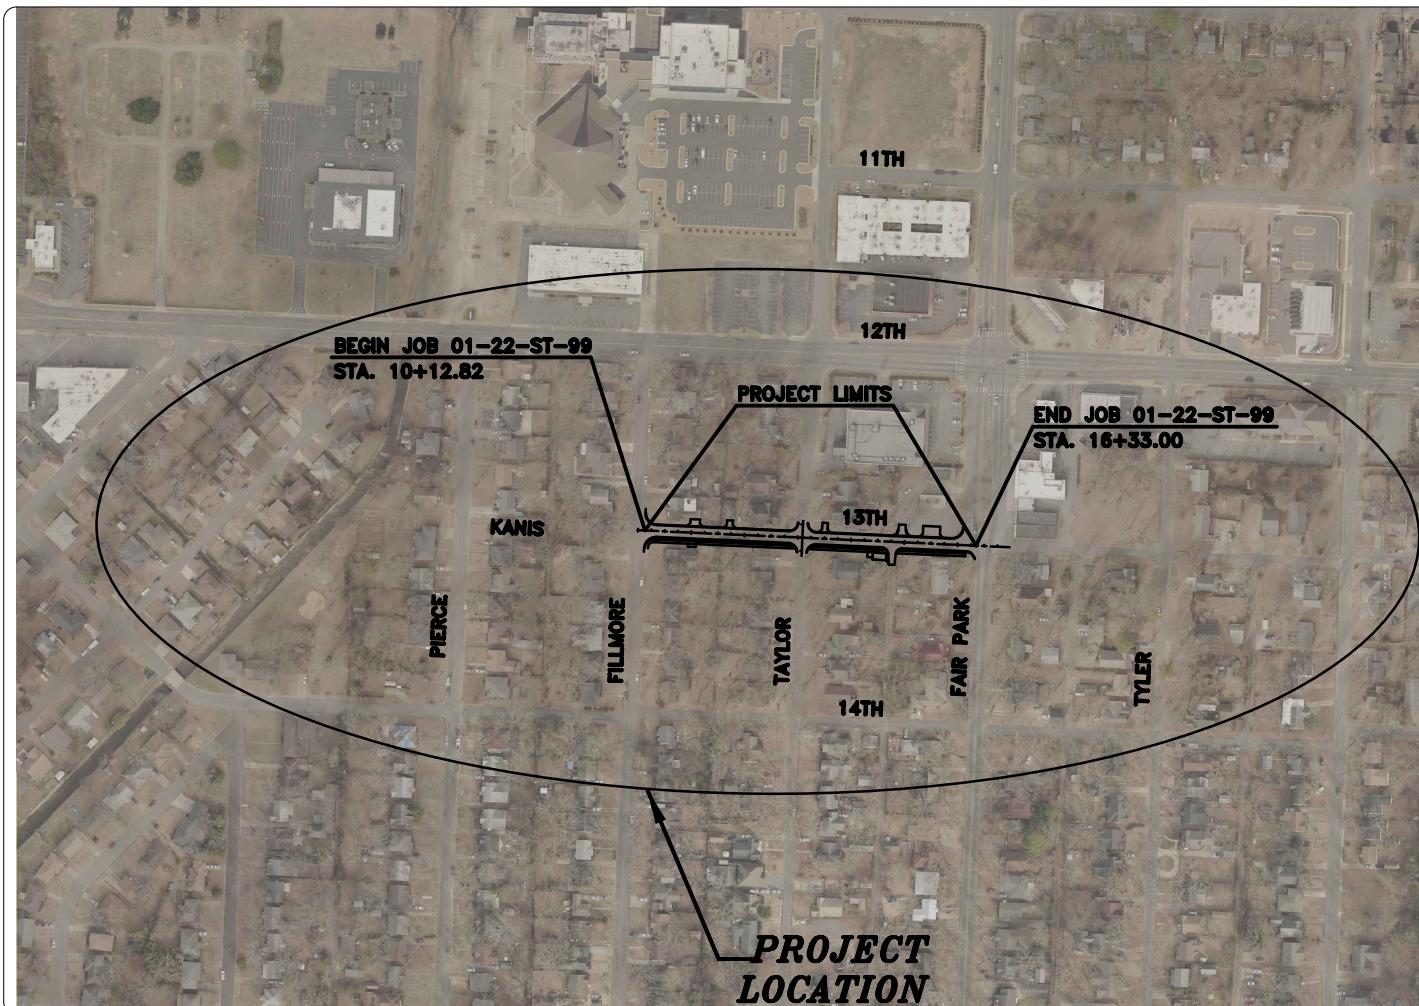

DEPARTMENT OF PUBLIC WORKS  
CIVIL ENGINEERING  
701 WEST MARKHAM STREET  
LITTLE ROCK, ARKANSAS 72201


**JACOBS**™

Jacobs Engineering Group, Inc.  
10816 Executive Center Dr., Suite 300  
Little Rock, Arkansas 72211  
Phone: 501.223.0515 Fax: 501.223.2470  
[www.jacobs.com](http://www.jacobs.com)

REVISIONS	DATE

CITY OF LITTLE ROCK, ARKANSAS
13TH STREET
COVER SHEET

DEPARTMENT OF PUBLIC WORKS
CIVIL ENGINEERING
701 W. MARKHAM
LITTLE ROCK, ARKANSAS 72201

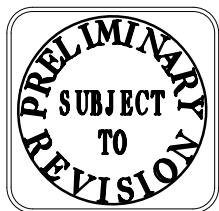


DRAWN BY	RFR
DESIGNED	RFR
CHECKED	BAP
DATE	12 / 5 / 23
SCALE	NTS
PROJECT NO.	01-22-ST-99
SHEET NO.	C-01

## **EXISTING**

 IRON ROD  
PK NAIL  
R.R. SPIKE  
CONC. MONUMENT  
WATER VALVE  
WATER METER  
FIRE HYDRANT  
GAS METER  
GAS VALVE  
CLEAN-OUT  
GUARD POST (BOLLARD)  
SIGN POST  
BENCHMARK  
  
STORM SEWER MANHOLE  
  
SANITARY SEWER MANHOLE  
  
TELEPHONE MANHOLE  
  
ELECTRIC MANHOLE  
  
TELEPHONE BOX  
ELECTRIC BOX  
CABLE BOX  
UTILITY POLE  
GUY WIRE  
LIGHT POLE  
POST OR POLE (TYPE AS NOTED)  
MAILBOX  
  
DECIDUOUS TREE  
  
EVERGREEN/CONIFEROUS TREE  
  
BUSH  
  
PROPERTY LINE  
SETBACK LINE  
EASEMENT LINE  
CURB  
FENCE  
OVERHEAD ELECTRIC  
OVERHEAD TELEPHONE  
OVERHEAD CABLE  
UNDERGROUND TELEPHONE  
UNDERGROUND ELECTRIC  
UNDERGROUND CABLE  
WATER LINE  
SEWER LINE  
GAS LINE  
  
STORM SEWER/CULVERT  
  
EDGE OF WOODS  
CONTOUR LINE

## **PROPOSED**


PROPOSED CONTOUR  
PROPOSED SPOT ELEVATION  
PROPOSED SPOT CURB ELEVATION  
STORM SEWER - PIPE  
STORM SEWER - MITERED END SECTION  
STORM SEWER - GRATE INLET  
STORM SEWER - JUNCTION BOX  
STORM SEWER - FLARED END SECTION  
STORM SEWER - HEADWALL  
STORM SEWER - SINGLE WING  
STORM SEWER - DOUBLE WING  
STORM SEWER - AREA INLET  
GRADE BREAK LINE  
HIGH POINT  
LOW POINT  
CUT LINE  
FILL LINE  
SANITARY SEWER PIPE  
SANITARY SEWER MANHOLE  
PROPOSED CURB  
PROPOSED CONCRETE  
CONSTRUCTION - ENTRANCE/EXIT  
CHECK DAM  
DIVERSION BERM  
DOWNDRAIN STRUCTURE - TEMPORARY  
ROCK DAM  
SEDIMENT BARRIER - SILT FENCE  
SEDIMENT BARRIER - GRAVEL RING  
SEDIMENT BARRIER - BLOCK & GRAVEL  
SEDIMENT BARRIER - BLOCK  
TEMPORARY SEDIMENT BASIN  
SILT FENCE - TYPE A  
SILT FENCE - TYPE B  
SILT FENCE - TYPE C  
STORM DRAIN OUTLET PROTECTION  
SURFACE ROUGHENING  
DISTURBED AREA STABILIZATION - TEMPORARY  
DISTURBED AREA STABILIZATION - TEMPORARY  
DISTURBED AREA STABILIZATION - PERMANENT  
MATTING/BLANKETS



CITY OF LITTLE ROCK, ARKANSAS  
13TH STREET

100

**DEPARTMENT OF PUBLIC WORKS  
CIVIL ENGINEERING  
701 W. MARKHAM  
LITTLE ROCK, ARKANSAS 72201**

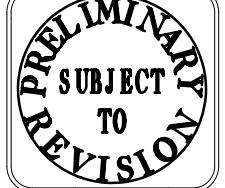


**DRAWN BY**  
**RFR**  
**DESIGNED**  
**RFR**  
**CHECKED**  
**BAP**  
**DATE**  
**12 / 5 / 23**  
**SCALE**  
**NTS**  
**PROJECT NO.**  
**01-22-ST-99**  
**SHEET NO.**  
**C - 02**

## CITY OF LITTLE ROCK, ARKANSAS

13TH STREET

TYPICAL SECTION

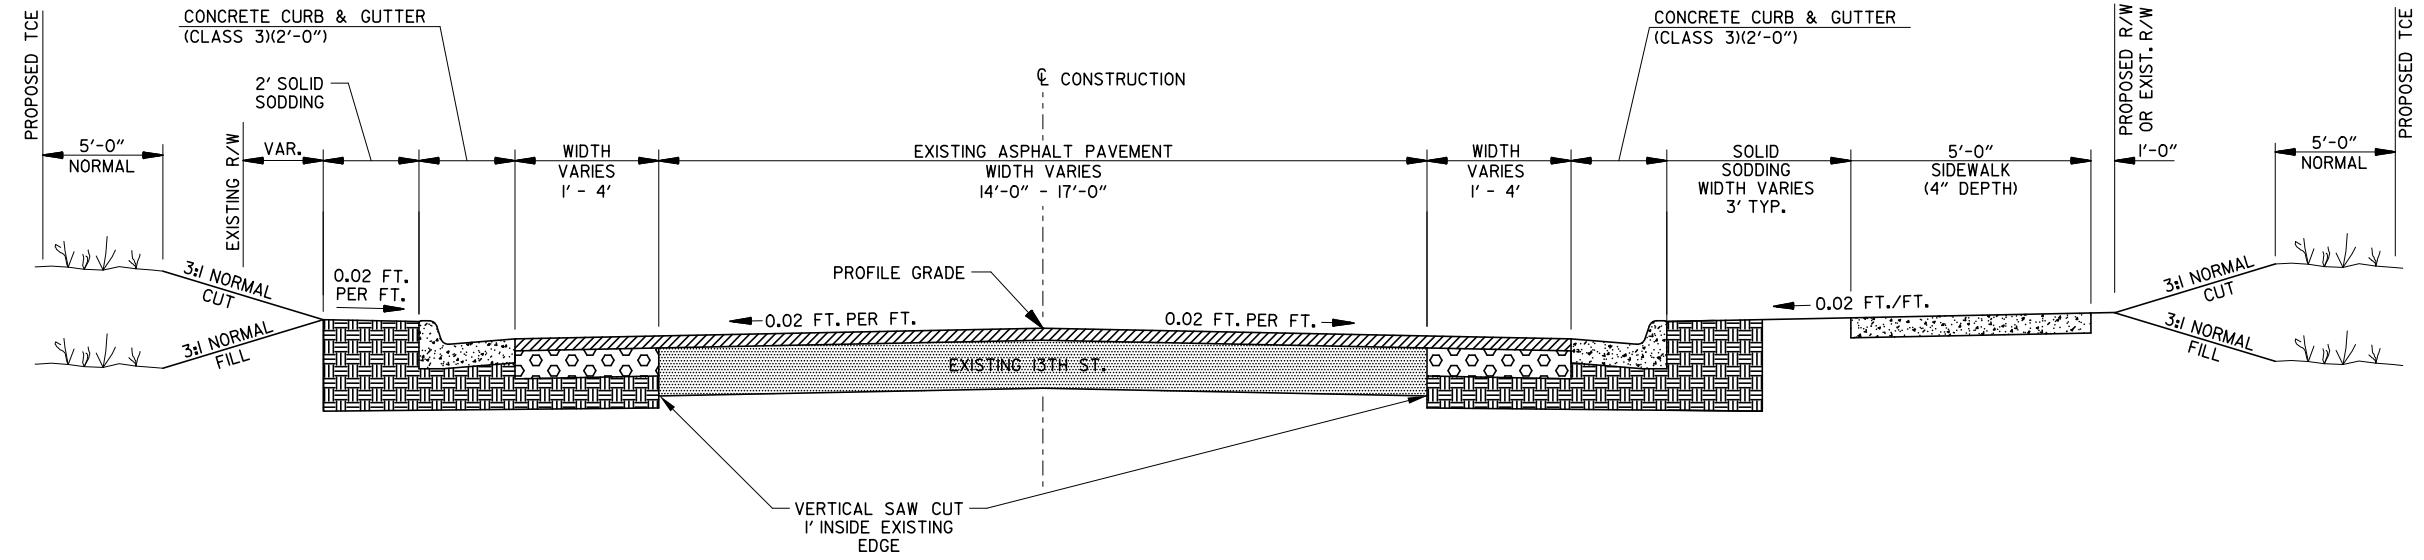


13TH STREET TYPICAL SECTION

STA. XX+XX. XX TO STA. XX+XX. XX

## NOTE:


- 1) REFER TO PW-22, PW-23, PW-29, PW-41, & PW-42 OF THE STANDARD DETAILS FOR ADDITIONAL INFORMATION.
- 2) REFER TO PLAN SHEETS AND CROSS SECTION FOR DEVIATIONS.

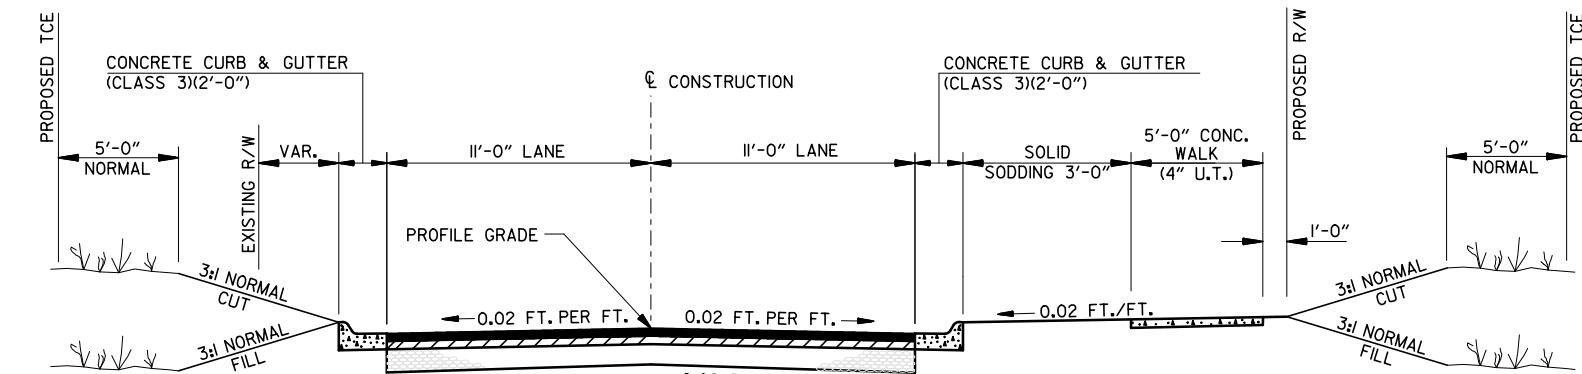

TANGENT SECTION - FULL DEPTH CONSTRUCTION

13TH STREET  
STA. XX+XX. XX TO STA. XX+XX. XX

DEPARTMENT OF PUBLIC WORKS  
CIVIL ENGINEERING  
701 W. MARKHAM  
LITTLE ROCK, ARKANSAS 72201

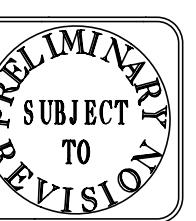



DRAWN BY
RFR
DESIGNED
RFR
CHECKED
BAP
DATE
12 / 5 / 23
SCALE
NTS
PROJECT NO.
01-22-ST-99
SHEET NO.
C - 03



REVISIONS DATE


## CITY OF LITTLE ROCK, ARKANSAS

## 13TH STREET

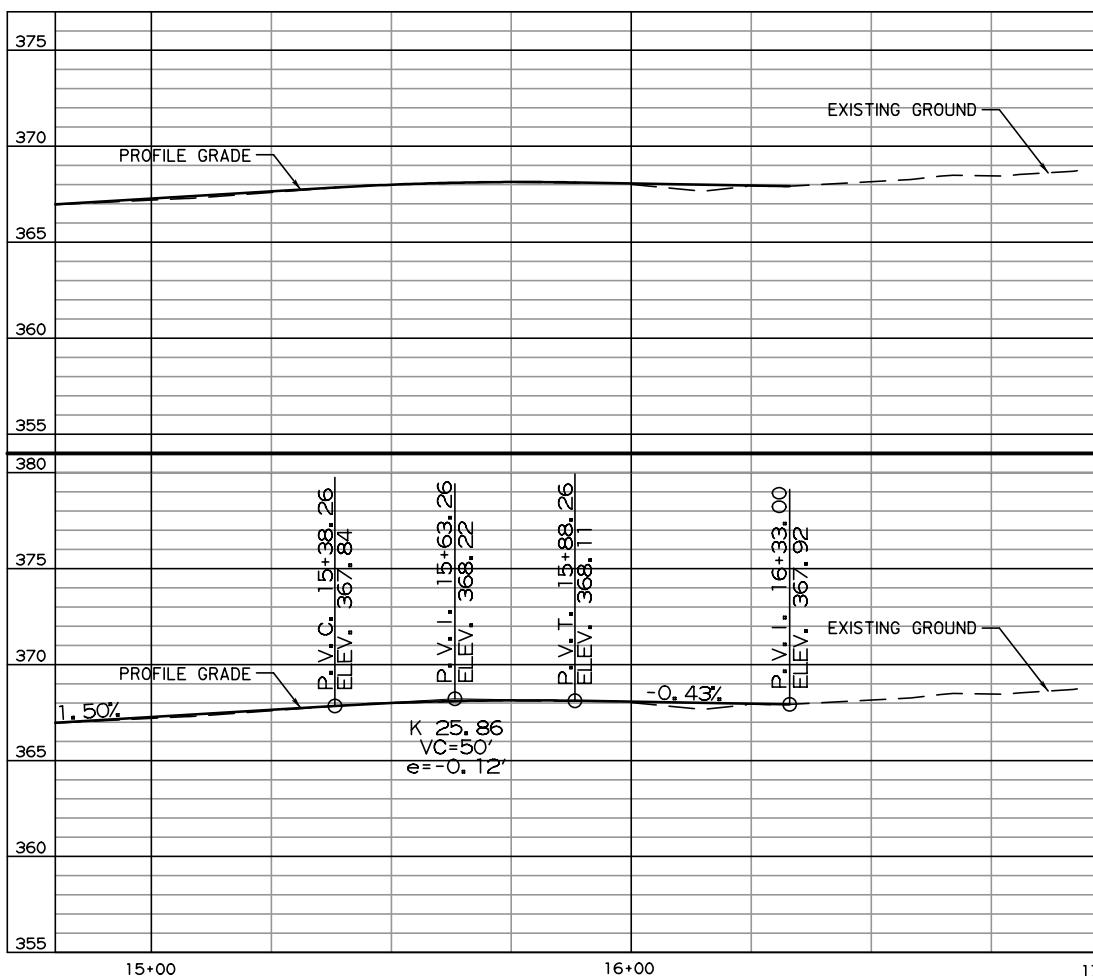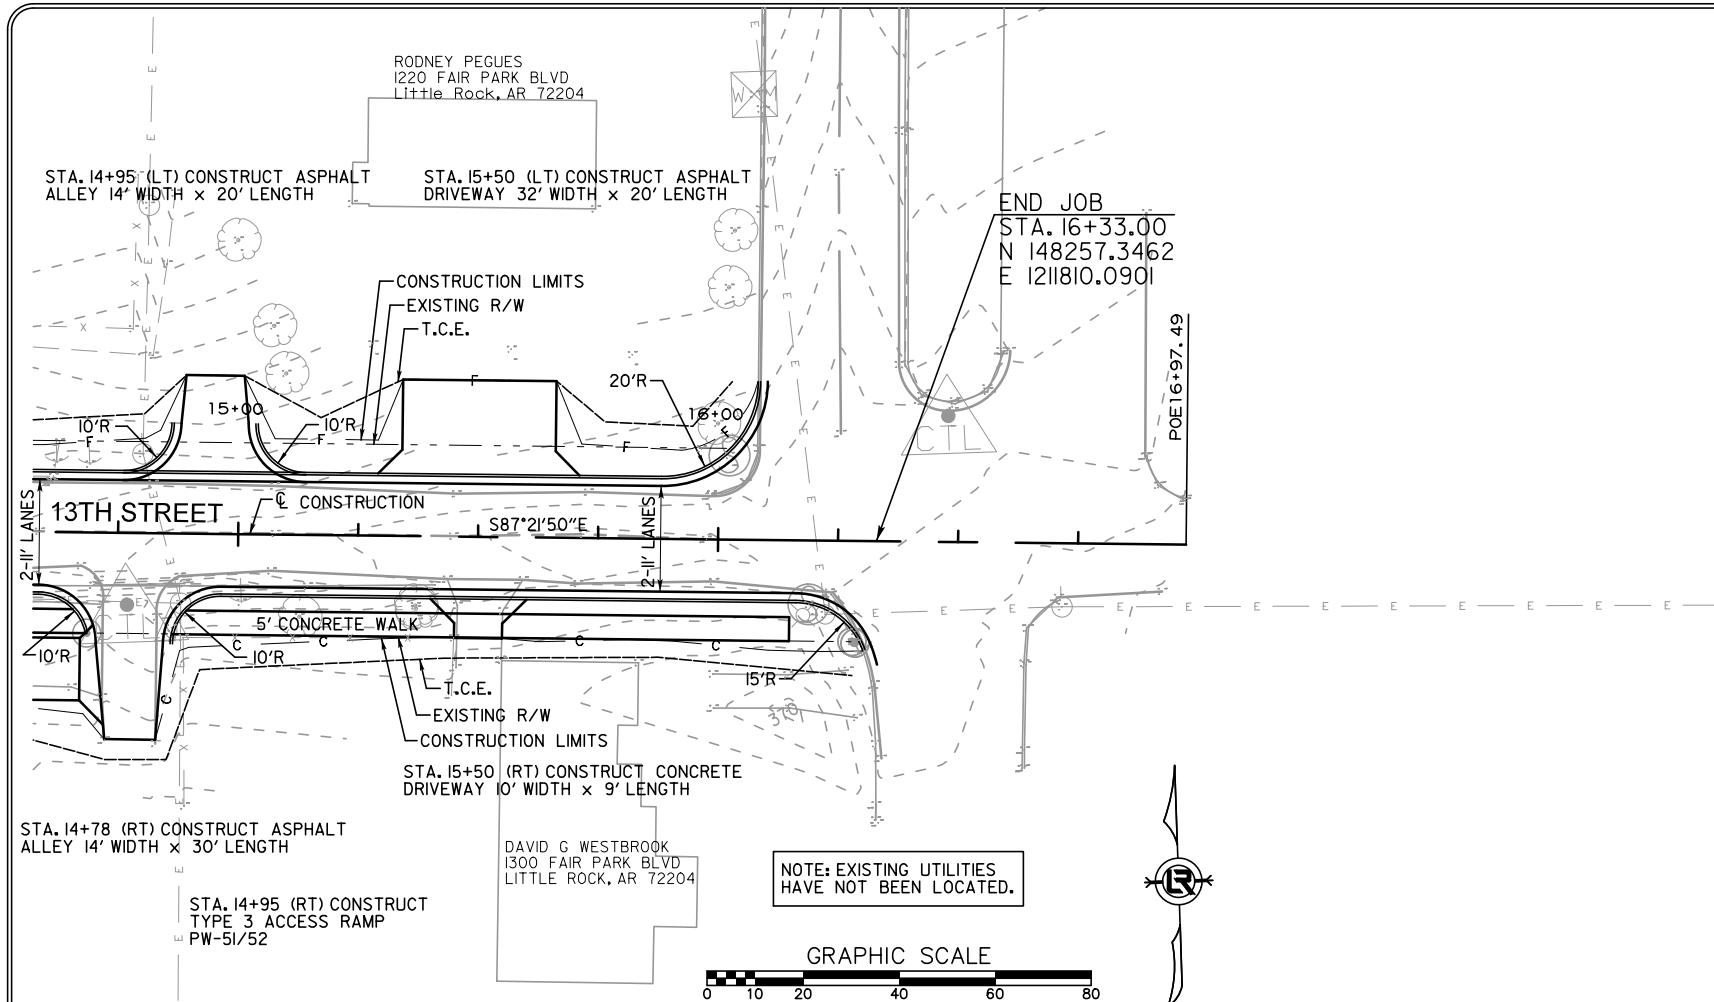PLAN & PROFILE  
13TH STREET SHEET 2

DEPARTMENT OF PUBLIC WORKS  
CIVIL ENGINEERING  
701 W. MARKHAM  
LITTLE ROCK, ARKANSAS 72201



DRAWN BY  
RFR  
DESIGNED  
RFR  
CHECKED  
BAP  
DATE  
12/5/23  
SCALE  
1" = 40'  
PROJECT NO.  
01-22-ST-99  
SHEET NO.  
C-05